





LOCATION MAP  
SCALE: NTS

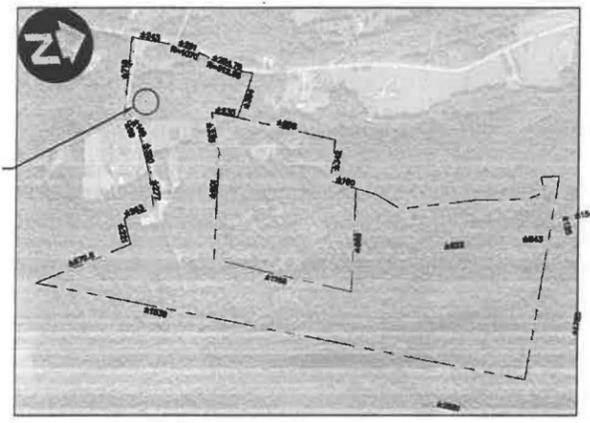



PARCEL MAP  
SCALE: NTS

- NOTES:
1. THE PROPERTY LINES, EASEMENTS, AND OTHER REAL PROPERTY DESCRIPTIONS PROVIDED ARE APPROXIMATE. THEY DO NOT DEFINE LEGAL RIGHTS OR MEET LEGAL REQUIREMENTS FOR A LAND SURVEY AS DESCRIBED IN 26.V.S.A(4), AND SHALL NOT BE USED IN LIEU OF A SURVEY AS THE BASIS OF ANY LAND TRANSFER OR ESTABLISHMENT OF ANY PROPERTY RIGHT.
  2. TOPOGRAPHIC SURVEY COMPLETED BY GREEN MOUNTAIN ENGINEERING DATED APR. 19, 2014 WITH AN ASSUMED DATUM.

- EXISTING**
- 802' --- PROPERTY LINE
  - INDEX CONTOUR
  - MINOR CONTOUR
  - TREE LINE
  - DRAINAGE DITCH
  - FENCE - WOOD
  - GRAVEL ROAD/DRIVE
  - CONCRETE SIDEWALK
  - UNPAVED TRAIL
- PROPOSED**
- 802' --- INDEX CONTOUR
  - 802' --- MINOR CONTOUR
  - TREE LINE
  - FM --- SANITARY SEWER
  - W --- WATER LINE
  - WELL
  - AIR RELEASE
- LEGEND**
- ⊙ TEST PIT
  - IRON PIN/PIPE/REBAR FOUND
  - BOUND
  - △ SURVEY STATION
  - ▲ SURVEY STATION - GPS

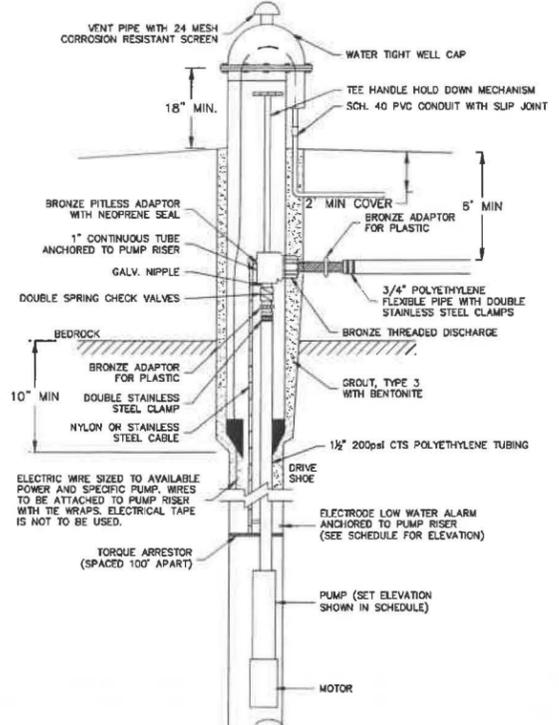

 TYPICAL INDIVIDUAL DRILLED WELL  
NOT TO SCALE

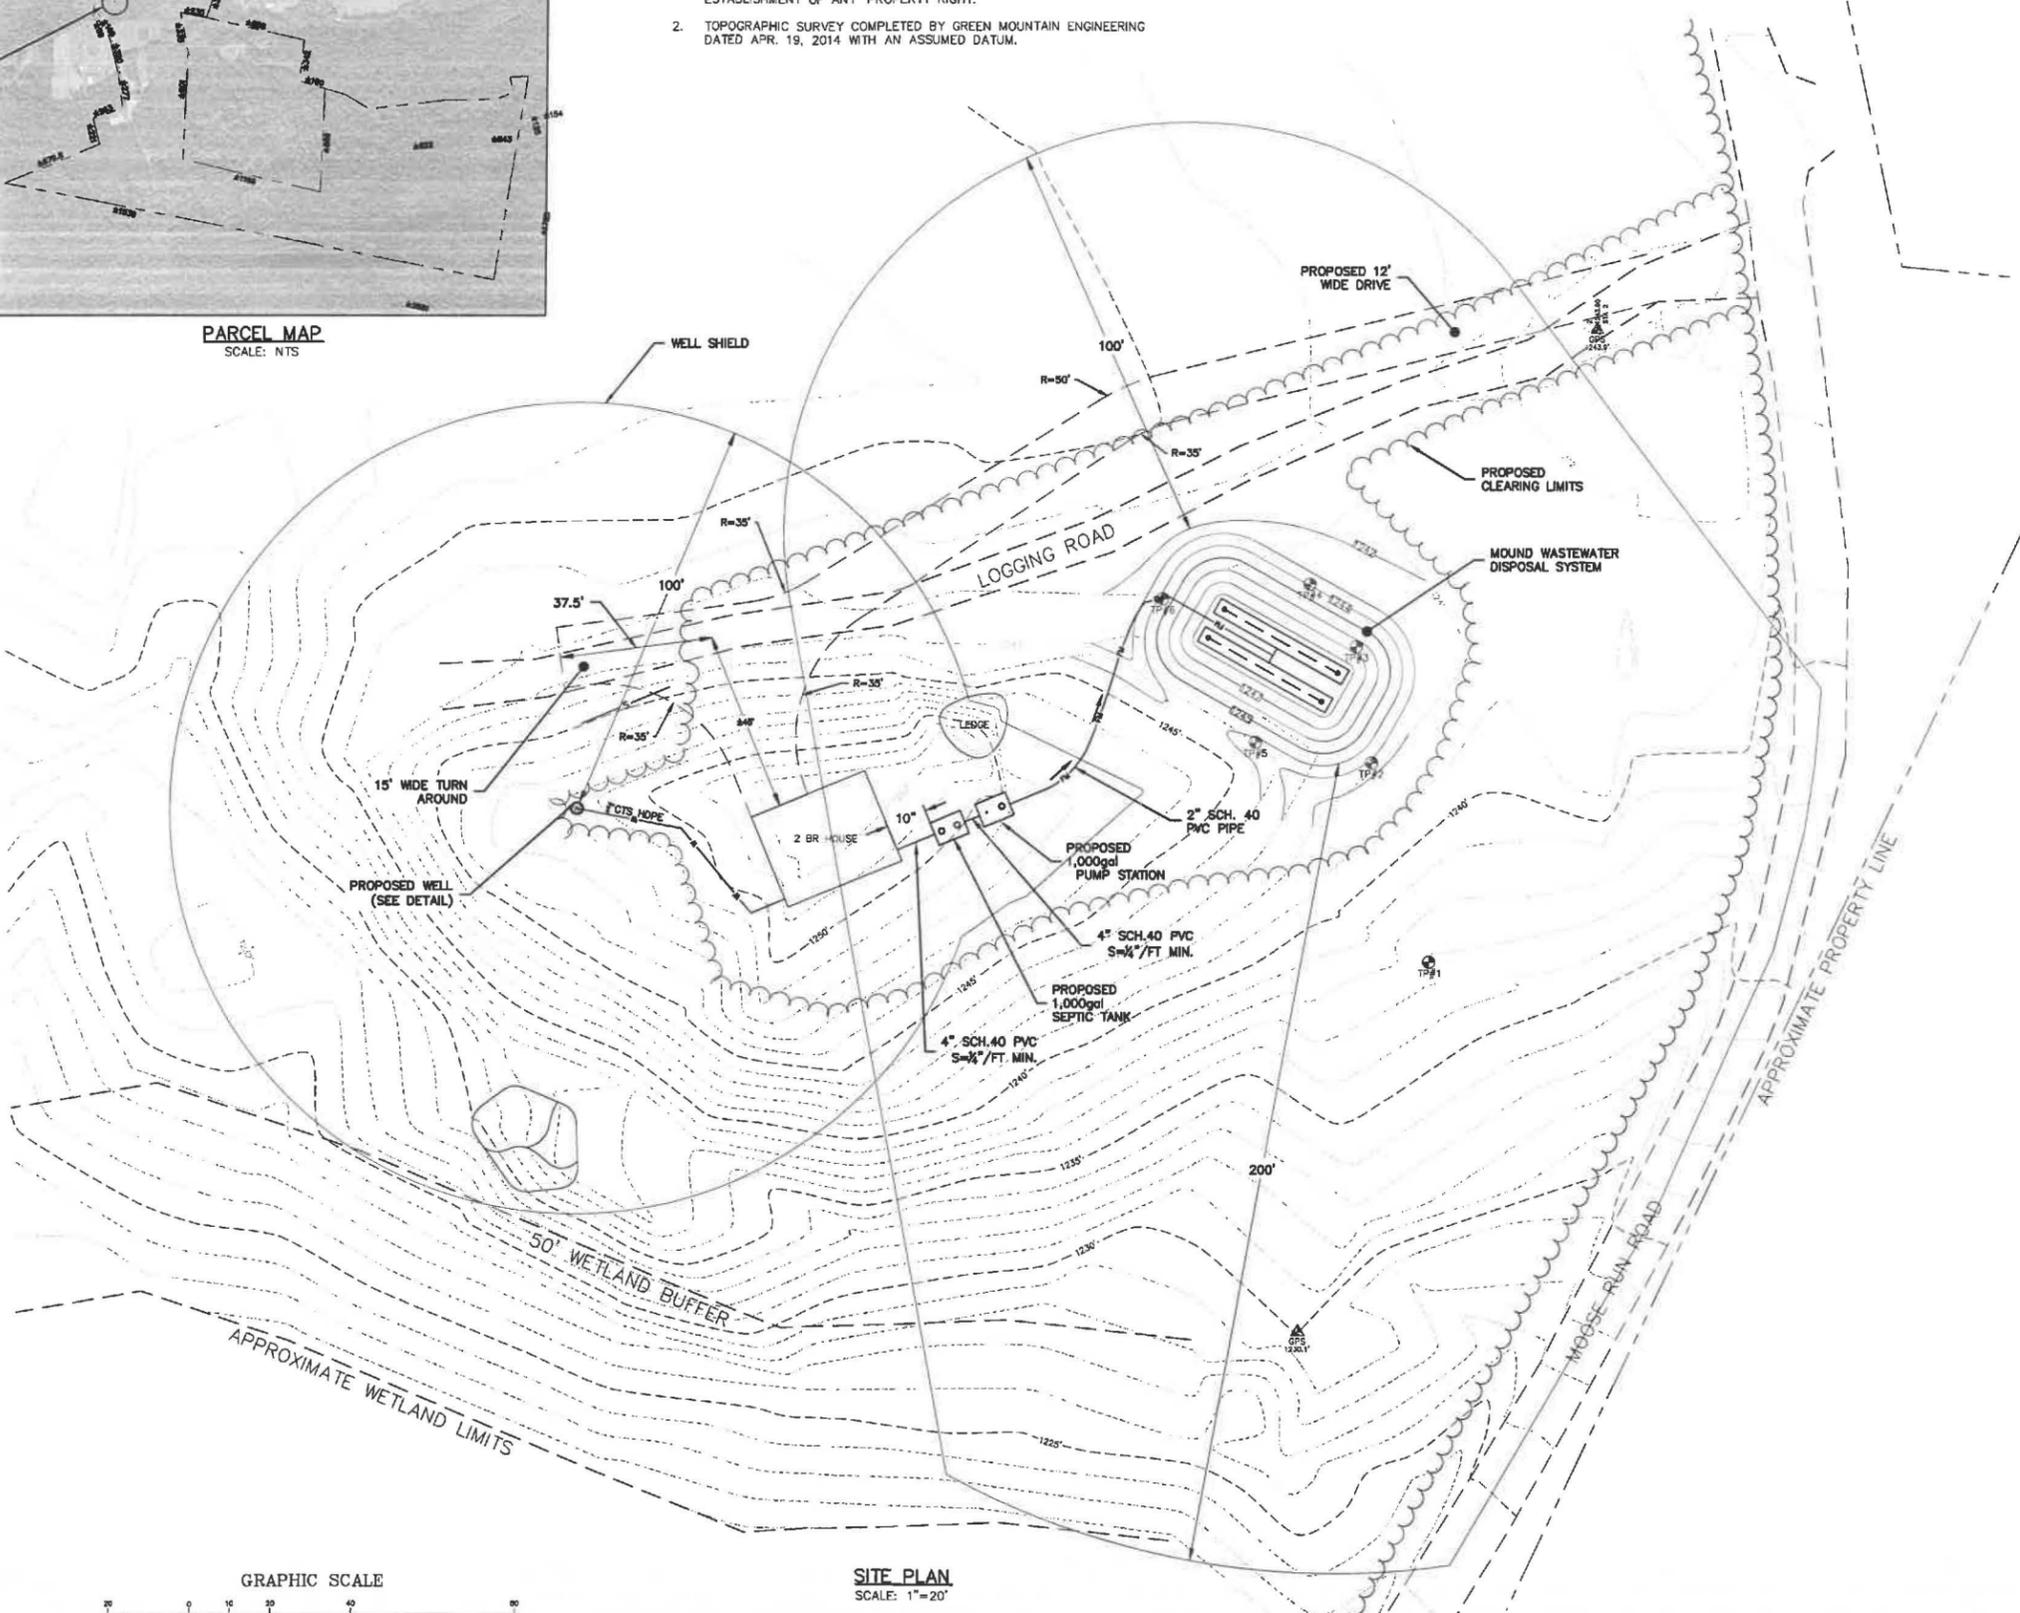

SITE PLAN  
SCALE: 1"=20'

1438 SOUTH BROWNELL ROAD  
WILKINSON, MISSISSIPPI 39256  
PHONE: (602)862-5580  
FAX: (602)862-7588

**GREEN MOUNTAIN ENGINEERING**  
CIVIL WATER WASTEWATER

REV.	DATE	DESCRIPTION	BY
06/04/18		ADDED TURN AROUND LABEL	JJB
03/01/18		REVISED PER AIR REVIEW COMMENTS	JJB

DRAWING TITLE		PROJECT		CLIENT	
PROPOSED SITE PLAN		POTVIN SEPTIC SYSTEM DESIGN		TIMOTHY AND THERESA POTVIN	
DESIGNED:	JJB	DATE:	01/12/18		
DRAWN:	JJB	SCALE:	1" = 20'		
CHECKED:	KJC	DATE:	JAN. 2018		
PROJECT NO.		27-041			
DRAWING NO.		1			
SHEET 1 OF 2					